


REV	DATE	SUMMARY
1	8/5/11	Client/Agency Comments
2	8/30/11	Agency Comments

Project #: 9130 Drawn: CL  
**COEUR D'ALENE DR  
 STREET &  
 STORM DRAINAGE  
 PLAN & PROFILE**  
 Date: April 15, 2011


**C4.4**

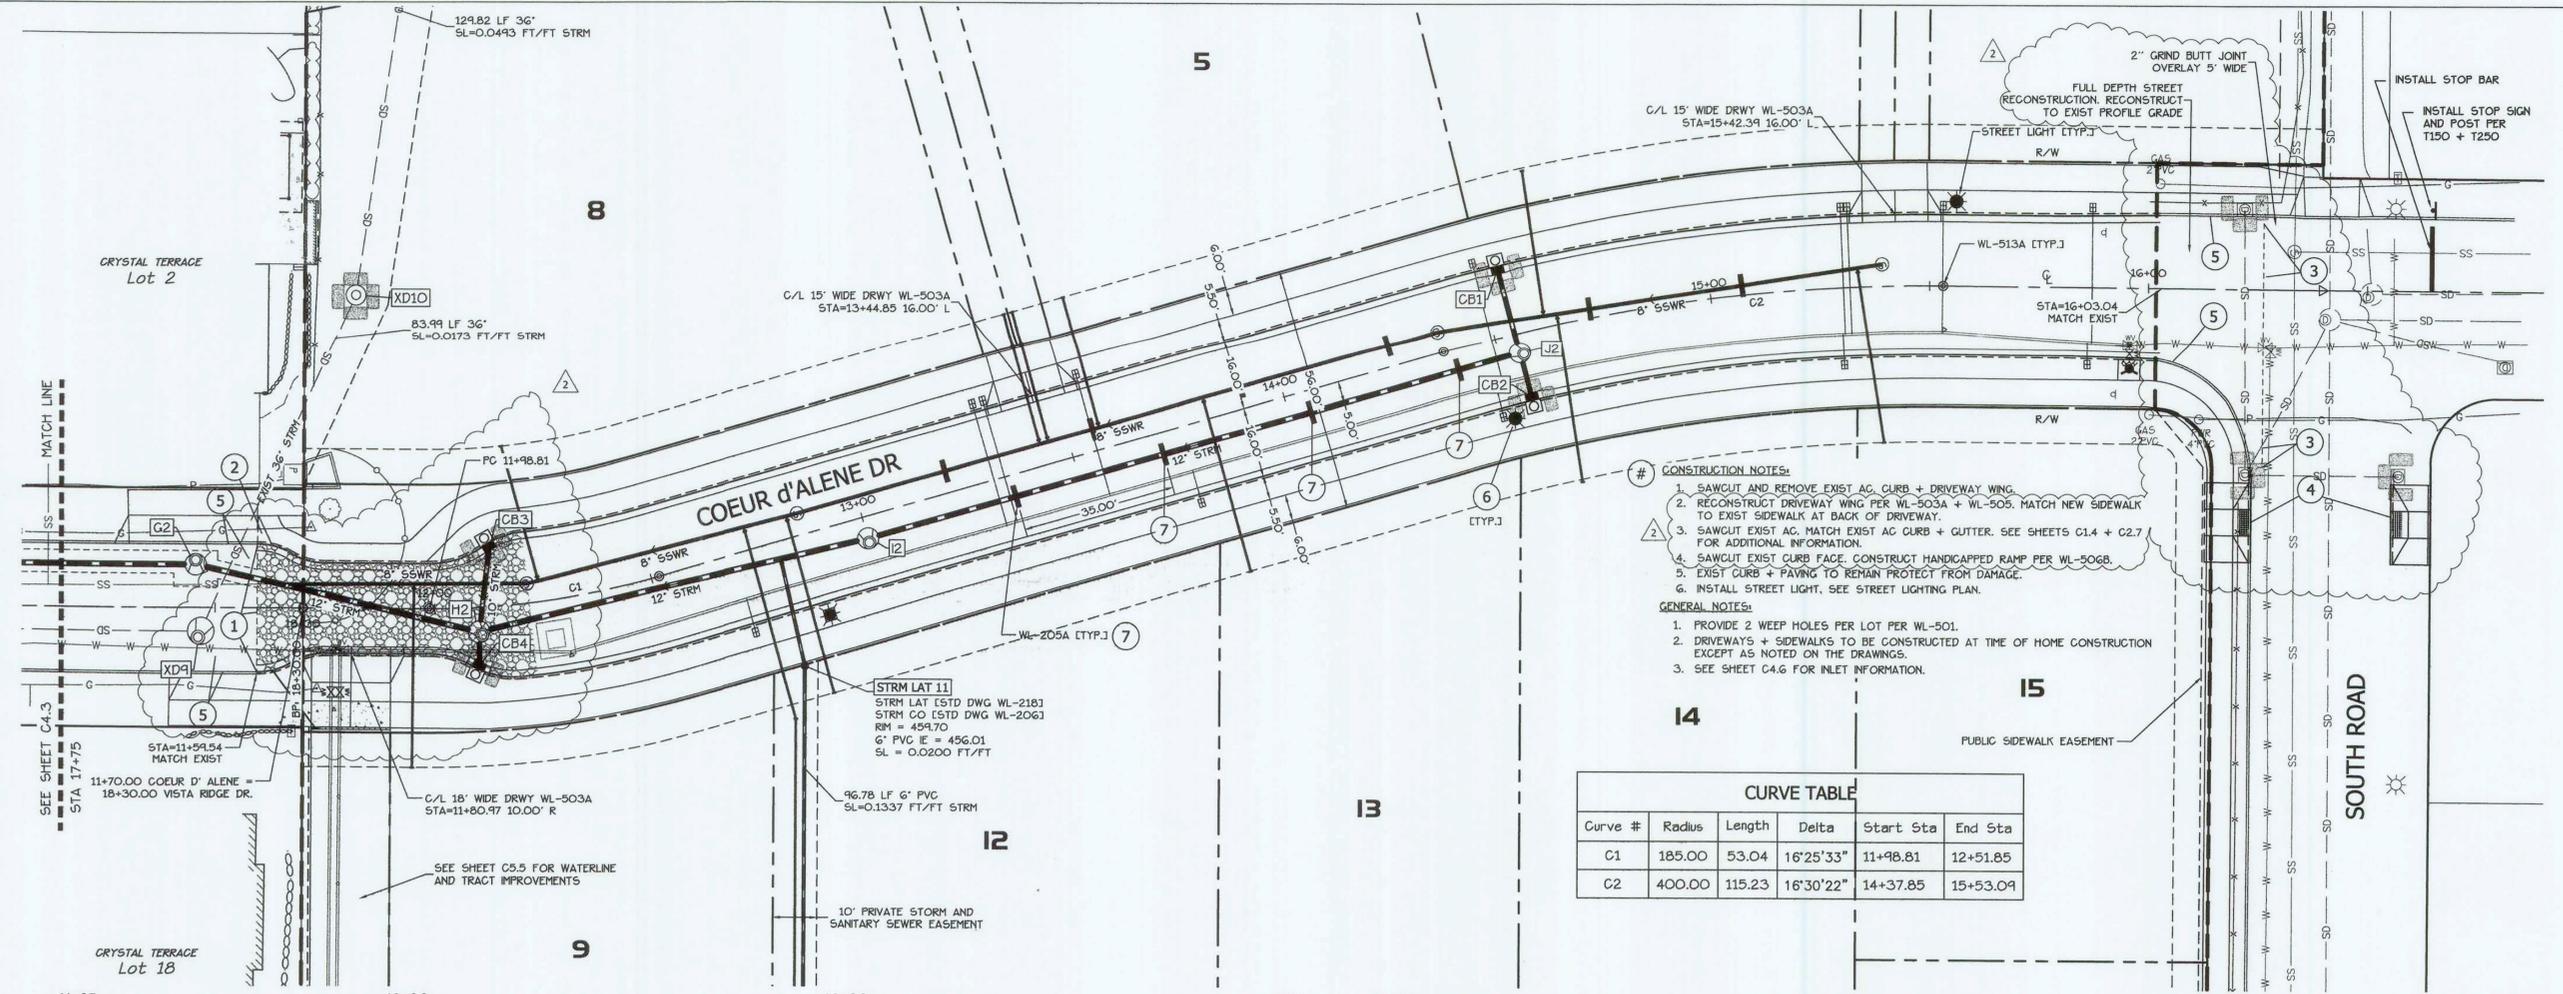

- CONSTRUCTION NOTES:**
- SAWCUT AND REMOVE EXIST AC CURB + DRIVEWAY WING.
  - RECONSTRUCT DRIVEWAY WING PER WL-503A + WL-505. MATCH NEW SIDEWALK TO EXIST SIDEWALK AT BACK OF DRIVEWAY.
  - SAWCUT EXIST AC. MATCH EXIST AC CURB + GUTTER. SEE SHEETS C1.4 + C2.7 FOR ADDITIONAL INFORMATION.
  - SAWCUT EXIST CURB FACE. CONSTRUCT HANDICAPPED RAMP PER WL-506B.
  - EXIST CURB + PAVING TO REMAIN PROTECT FROM DAMAGE.
  - INSTALL STREET LIGHT. SEE STREET LIGHTING PLAN.
- GENERAL NOTES:**
- PROVIDE 2 WEEP HOLES PER LOT PER WL-501.
  - DRIVEWAYS + SIDEWALKS TO BE CONSTRUCTED AT TIME OF HOME CONSTRUCTION EXCEPT AS NOTED ON THE DRAWINGS.
  - SEE SHEET C4.6 FOR INLET INFORMATION.

**CURVE TABLE**

Curve #	Radius	Length	Delta	Start Sta	End Sta
C1	185.00	53.04	16°25'33"	11+98.81	12+51.85
C2	400.00	115.23	16°30'22"	14+37.85	15+53.09

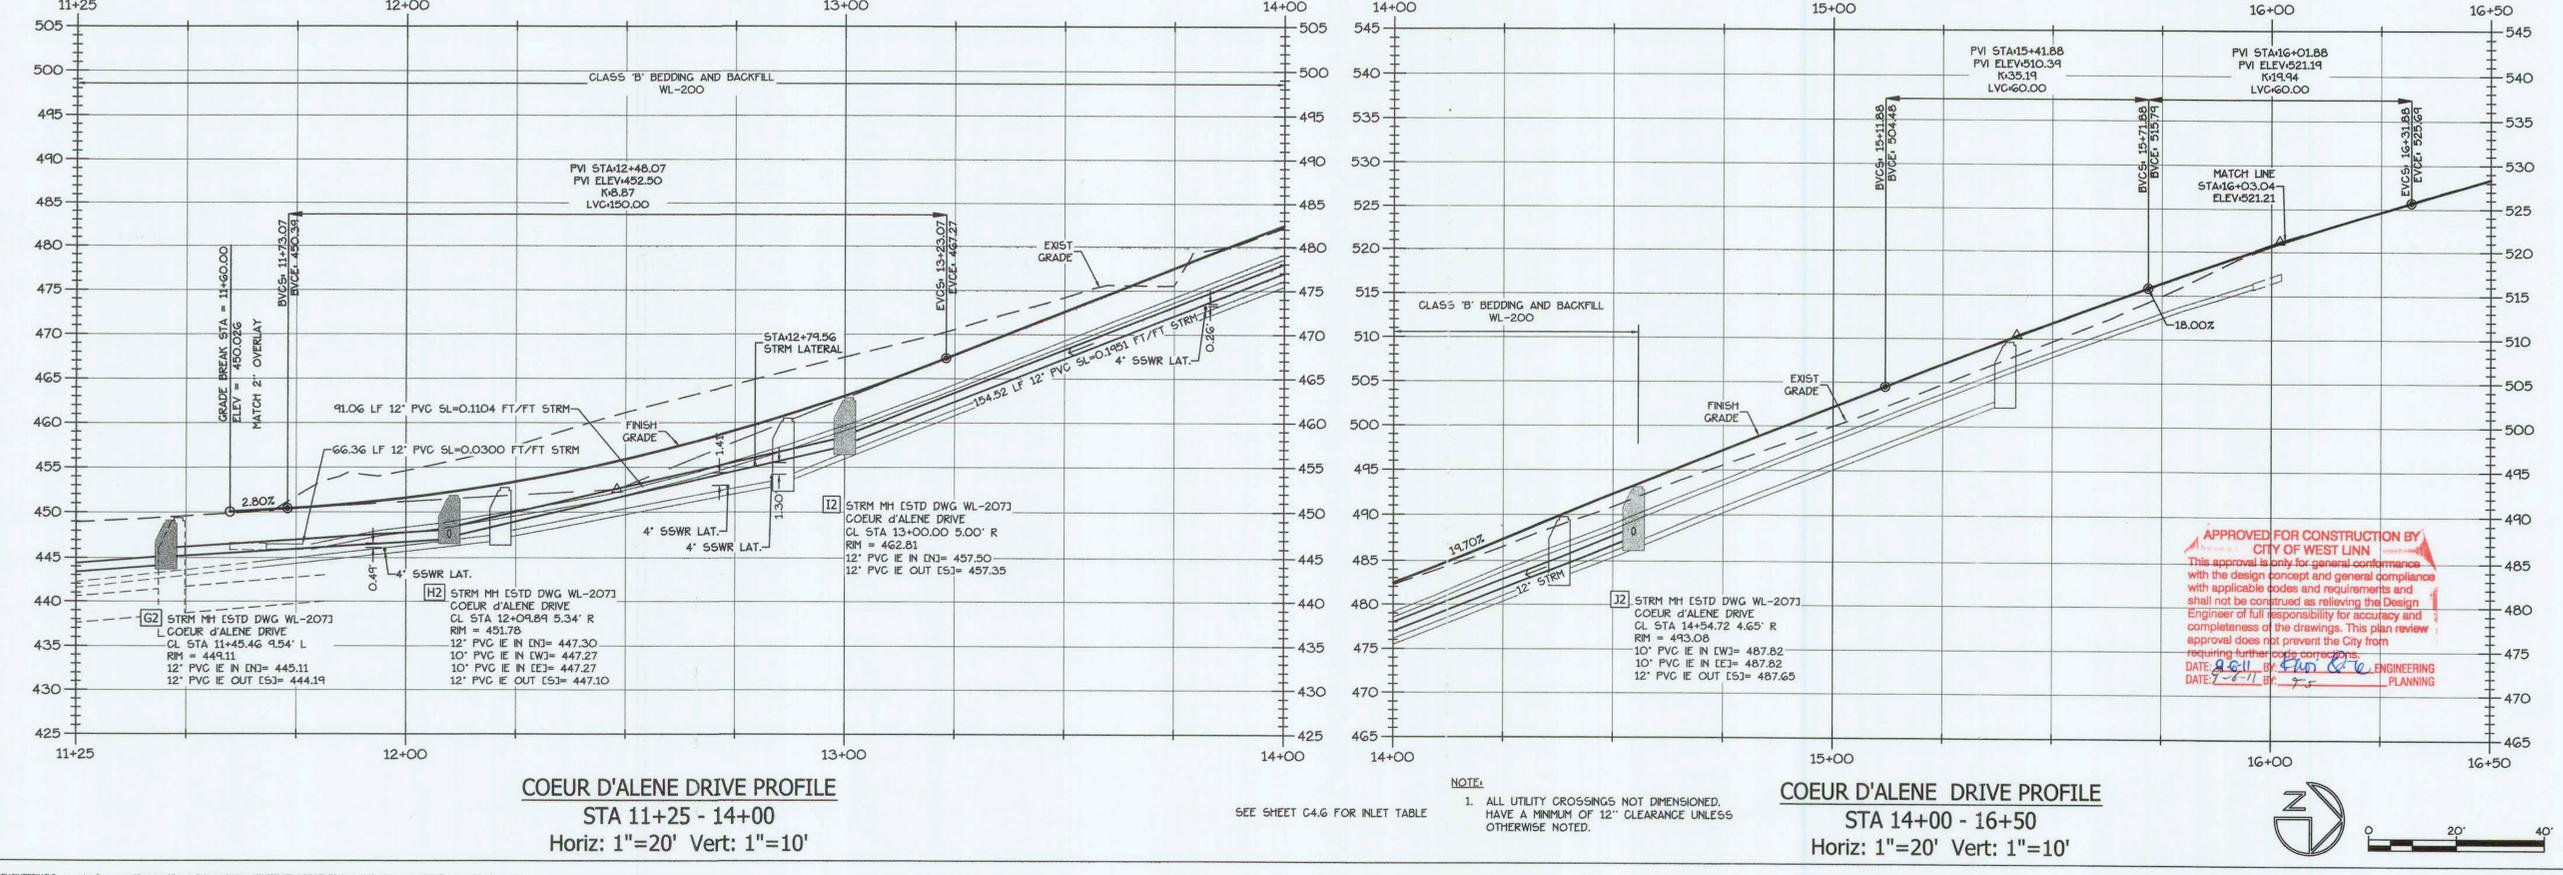

**APPROVED FOR CONSTRUCTION BY**  
 CITY OF WEST LINN  
 This approval is only for general conformance with the design concept and general compliance with applicable codes and requirements and shall not be construed as relieving the Design Engineer of full responsibility for accuracy and completeness of the drawings. This plan review approval does not prevent the City from requiring further code corrections.  
 DATE: 8-11-11 BY: [Signature] ENGINEERING PLANNING

**NOTE:**  
 1. ALL UTILITY CROSSINGS NOT DIMENSIONED. HAVE A MINIMUM OF 12" CLEARANCE UNLESS OTHERWISE NOTED.

