


1 ROSEMONT ROAD - SURFACE PROFILE (STA: 15+50 TO 21+00)
 P13.2/P13.2 SCALE: H: 1"=20'-0" V: 1"=4'-0"


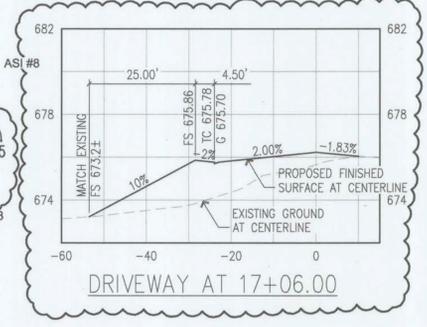


SITE CONSTRUCTION NOTES


(NOTE: NOT ALL NOTES USED ON THIS PLAN)

- 1 CONSTRUCT STANDARD CURB AND GUTTER. P13.1/P15.2
- 2 INSTALL ASPHALT PAVEMENT. P13.1/P11.2
- 3 INSTALL CONCRETE SIDEWALK. P13.1/P15.2
- 4 CONSTRUCT CONCRETE DRIVEWAY WITH RAISED PEDESTRIAN CROSSING. P13.1/P15.4
- 6 INSTALL ASPHALT PATH. P13.1/P15.2
- 7 CONTRACTOR SHALL PATCH & REPAIR ALL EXISTING ASPHALT PAVING THAT IS DAMAGED DURING CONSTRUCTION. P13.1/P15.4
- 8 MATCH EXISTING AC PAVING, PROVIDE TACK COAT AT JOINT.
- 10 INSTALL CENTER TURN LANE STRIPING AND REFLECTORS FROM HIDDEN SPRINGS ROAD TO BAY MEADOWS DRIVE. P13.1/P15.4
- 11 INSTALL 4" WIDE WHITE BIKE LANE STRIPING - BIKE LANE SYMBOL.
- 12 INSTALL NEW MAILBOXES, PER WL-514. PROVIDE 4' CLEARANCE. P13.1/P15.3
- 13 RELOCATE POWER POLE - SEE ELECTRICAL PLAN. NO OVERHEAD UTILITY OR POLE ALLOWED ALONG PROJECT FRONTAGE.

- 14 INSTALL NEW LIGHT POLE - SEE ELECTRICAL SITE PLAN. (24" FACE OF CURB TO FACE OF POLE)
- 18 SEE ON-SITE IMPROVEMENTS FOR CONSTRUCTION INFORMATION.
- 21 INSTALL CONCRETE RESIDENTIAL DRIVEWAY AND ADA RAMP WITH 24" WIDE TRUNCATED DOME WARNING STRIP.
- 22 INSTALL MODULAR CONCRETE BLOCK RETAINING WALL AND PEDESTRIAN GUARD RAIL.

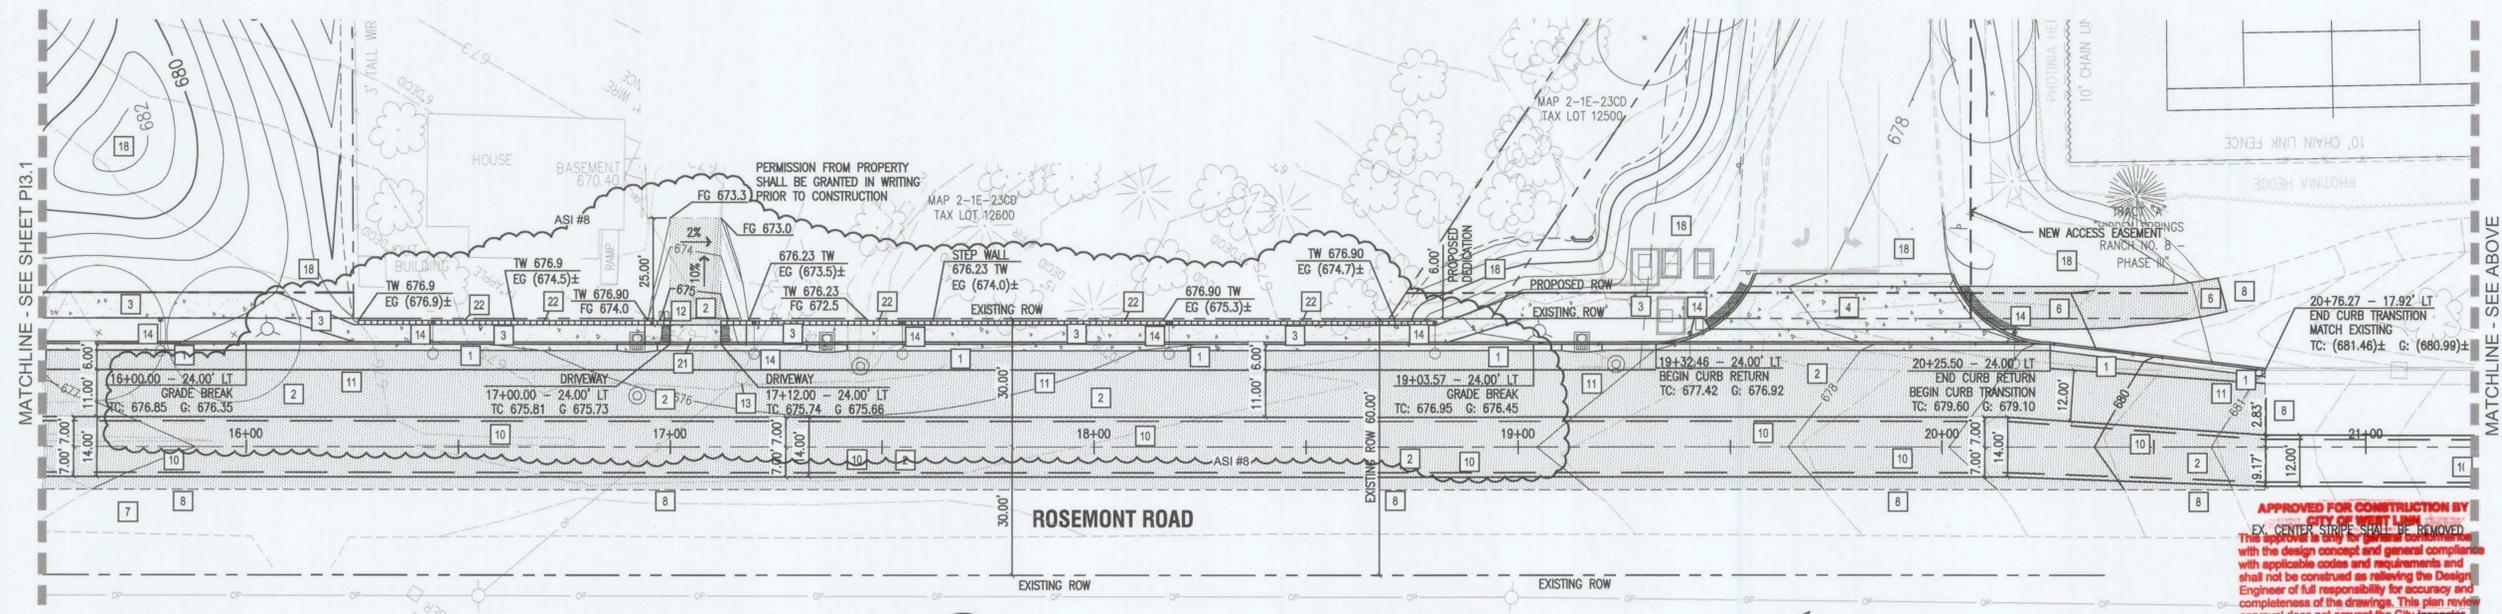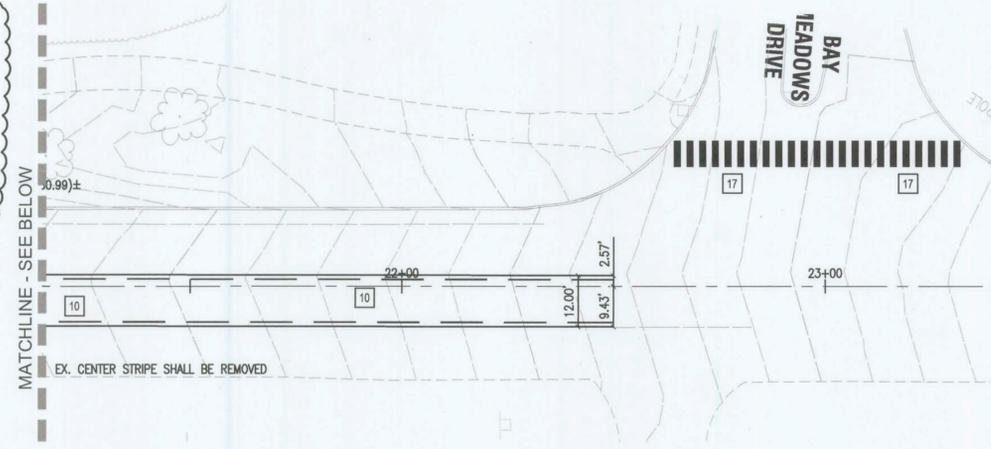

 2 ROSEMONT ROAD - SURFACE PLAN (STA: 15+50 TO 21+00)
 P13.2/P13.2 SCALE: 1"=20'-0"



dowa
 ARCHITECTURE • INTERIORS • PLANNING
 DULL OLSON WEEKES
 architects inc.
 807 SW STARK STREET, PORTLAND, OR 97204
 t: 503 226 8950 f: 503 273 9192 www.dowa.com

TRILLIUM CREEK PRIMARY SCHOOL
 West Linn Wilsonville School District
 22210 SW STAFFORD ROAD - WEST LINN, OR 97068
 t: (503) 673 7976
 f: (503) 673 7044

WINZLER & KELLY
 15575 SW SEQUOIA PARKWAY, SUITE 140
 PORTLAND, OR 97224
 PH (503) 226-3921 • FAX (503) 226-3926
 WWW.W-AND-K.COM

REGISTERED PROFESSIONAL ENGINEER
 13,727
 OREGON
 JULY 16, 1987
 MARK B. WHARRY
 EXPIRES 6/30/12

phase	CONSTRUCTION
	SET
date	April 6, 2011
revisions	
ASI #8	06/29/2011
project #	09014
SURFACE IMPROVEMENTS STA: 15+50 TO 21+00	

P13.2